



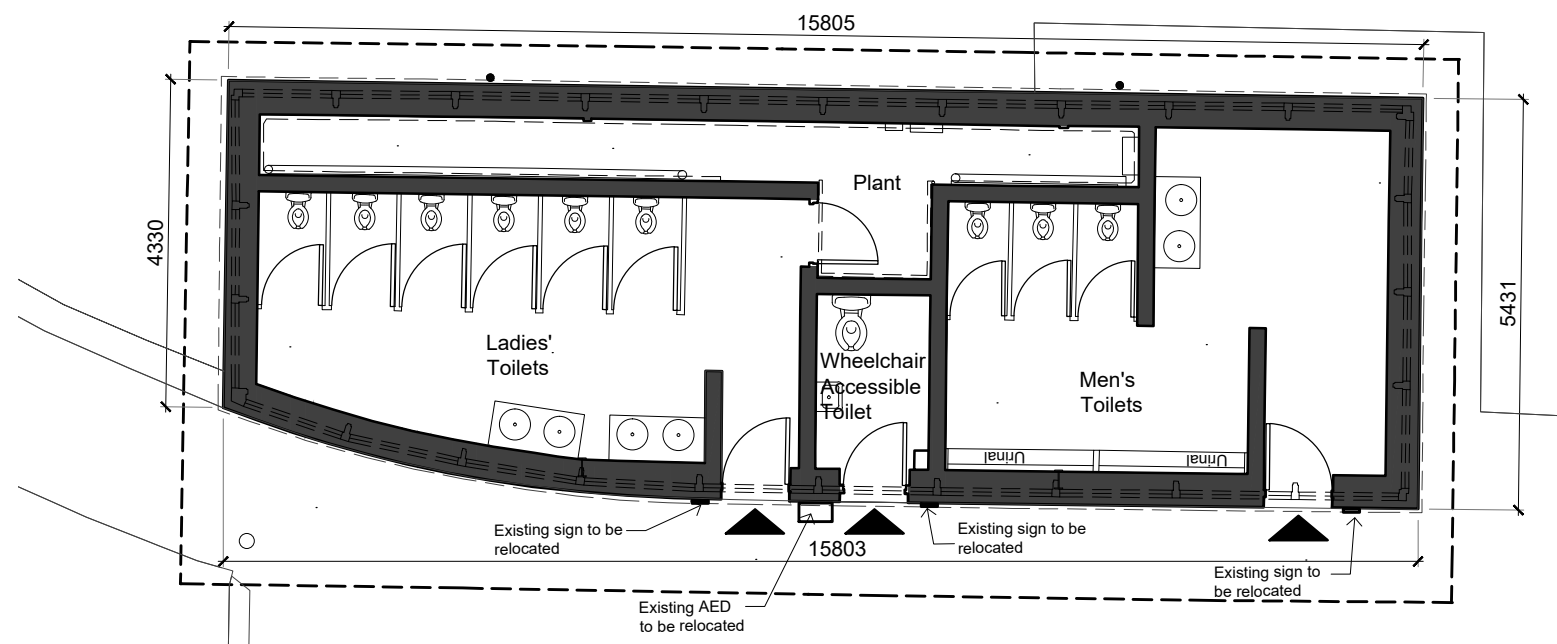

1 Ground Floor Plan of Existing Public Toilet Facilities
Scale 1:100

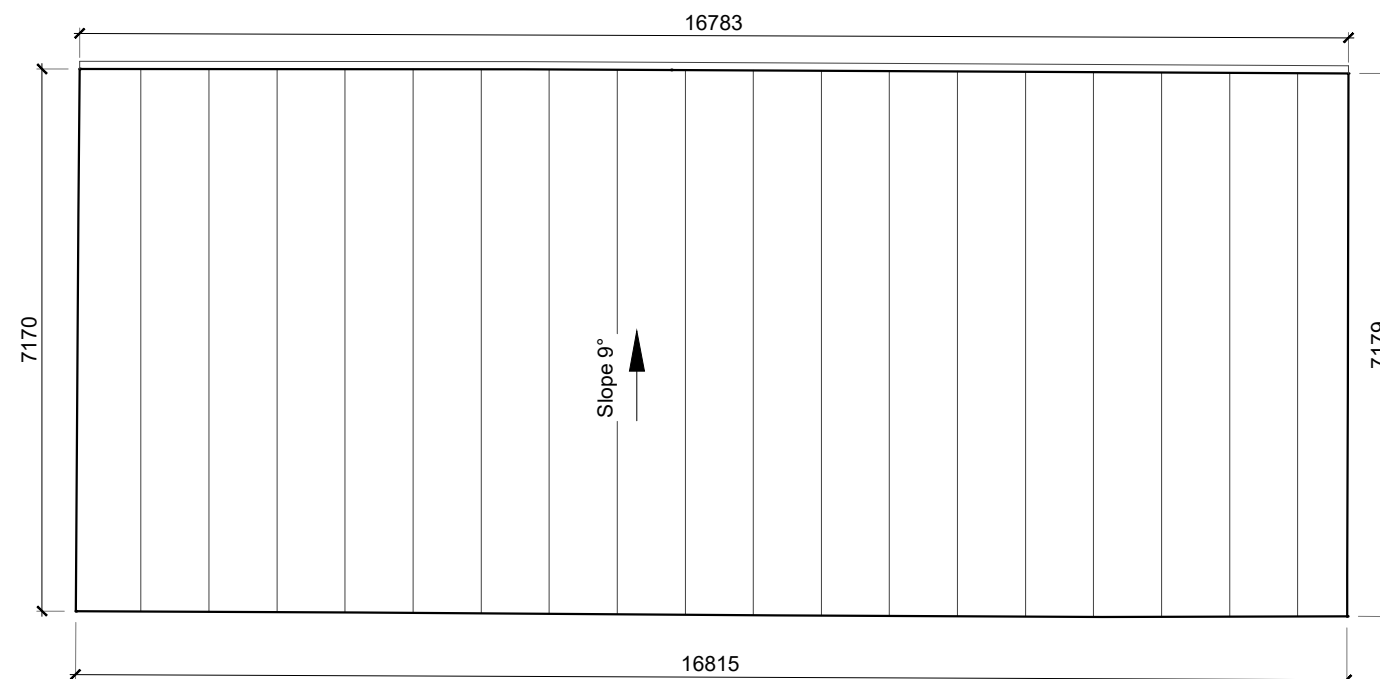

2 Roof Plan of Existing Public Toilet Facilities
Scale 1:100

Rev.	Date	Drawn	Description	Do not scale from this Drawing, use figured dimensions only. Check all dimensions on site before commencing work. Report any discrepancies to Architect before proceeding. This Drawing and Designs thereon are copyright of the County Council. ©				Job	Scale @	Status
-	-	-	-					Fáilte Ireland Facility Centre, Killiney	A3 1:100	PART 8
-	-	-	-						October 2026	Rev. -
-	-	-	-					Drg. Existing Ground Floor and Roof Plan	Job No. 1914	CAD Ref.
-	-	-	-						Dm. HA/ ERL Chd. -	1914-DLR-ZZ-ZZ-M2-A-1000-PLAN
-	-	-	-					Drawing No. 1914-DLR-ZZ-ZZ-DR-A- 1110	Architects Department County Hall, Marine Road, Dun Laoghaire, Co. Dublin. Phone (01)2054700 Fax (01)2300391	



© - Ordnance Survey Ireland. All rights reserved.
Licence number 2013-2015/CCMA/
Dun Laoghaire-Rathdown County Council.