


LEGEND	
EXISTING SERVICES	
EXISTING BUILDINGS	
NEW BUILDING EXTENSION	
ROADWAY	
PARKING AND ACCESS	
FOOTPATHS	
LANDSCAPING	
EXISTING TELECOMS DUCTS	
EXISTING GAS LINE	
EXISTING ESB DUCTS	
EXISTING EIRCOM DUCTS	
EXISTING LIGHTING DUCTS	
EXISTING STONE DRAIN	
EXISTING LATERAL DRAINS	
EXISTING PUMP IRRIGATION	
EXISTING FRENCH DRAIN	
EXISTING LAND DRAIN	
EXISTING SERVICE DUCTS	
EXISTING IRRIGATION	
EXISTING COMBINED	
EXISTING ELECTRICAL CABLES	
EXISTING VIRGIN MEDIA CABLE	
EXISTING SLEEPER DRAIN	

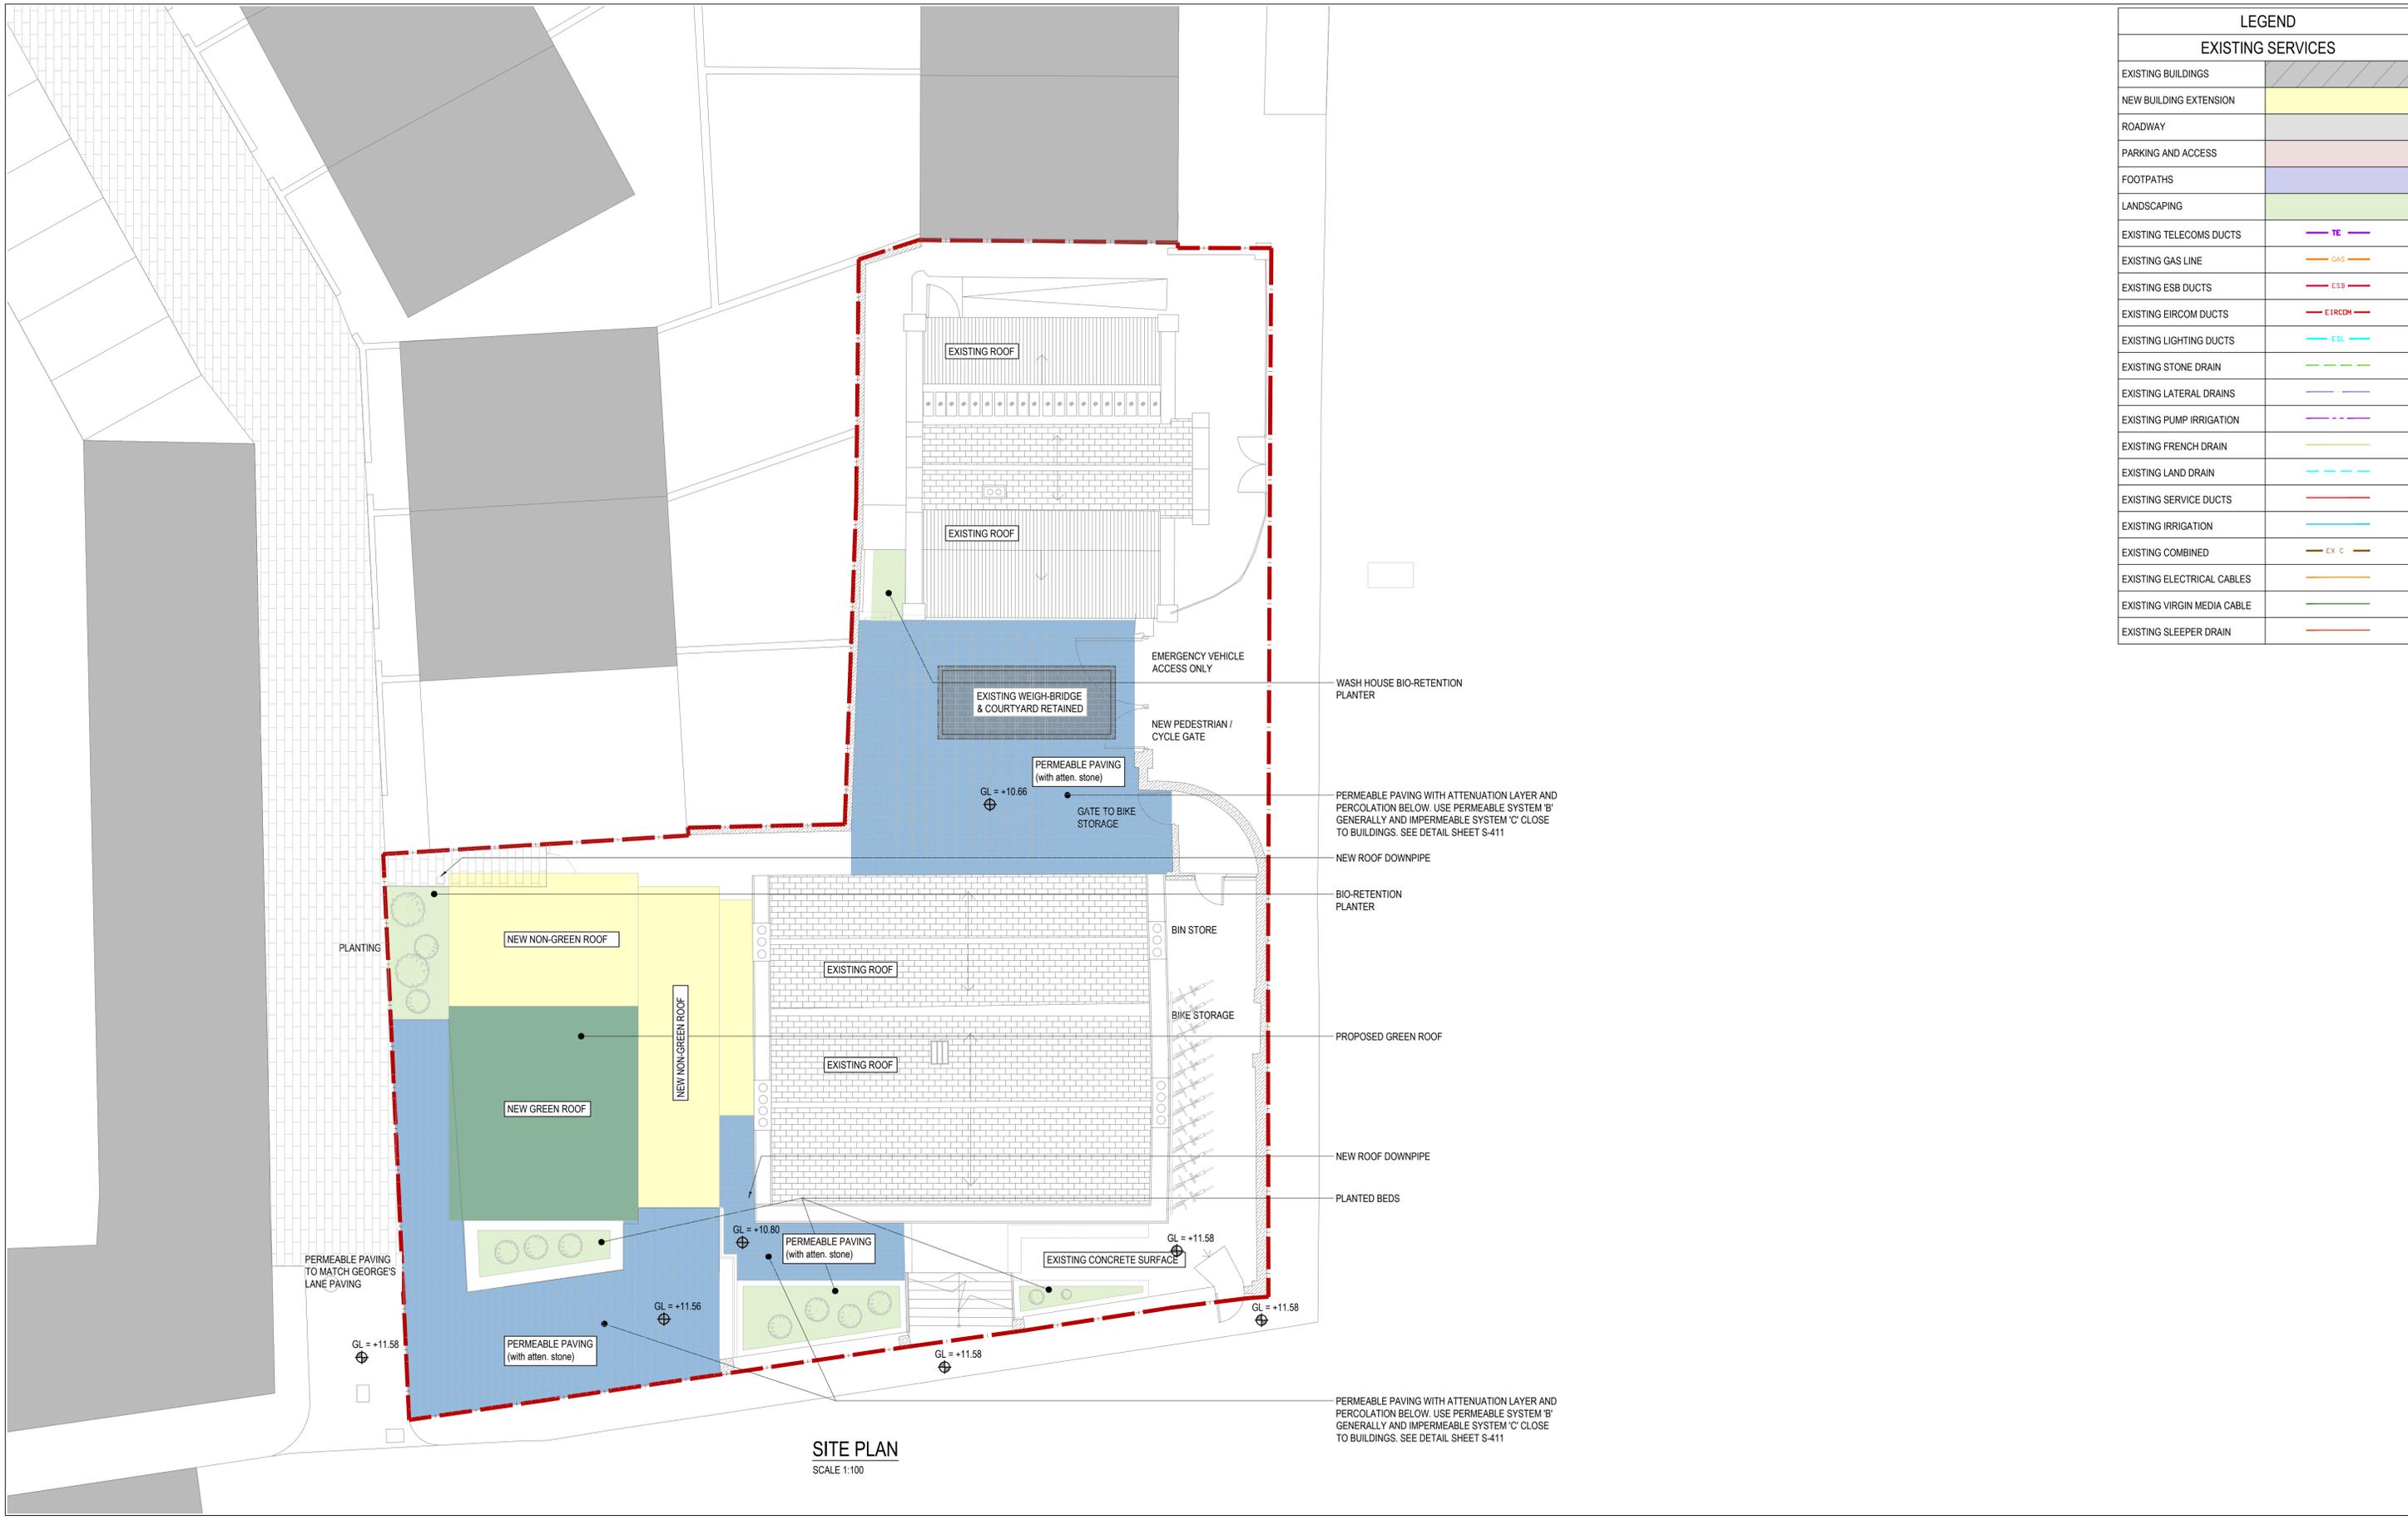

**NOTES:**  
For setting out refer to Architect's drawings. This drawing to be read in conjunction with all other Architectural and Engineering drawings and all other relevant drawings and Specifications. DO NOT SCALE THIS DRAWING. Figured dimensions only to be used in all cases. Verify dimensions on site and report any discrepancies immediately. This drawing is copyright and must not be reproduced, transmitted or stored in any form without the permission of STEM Consulting Engineers Ltd. except as agreed on this project.

Rev	Dm	Chkd	Amendments	Date
P02	BP	AS	FOR PART 8	11.02.2025
P01	BP	AS	FOR COMMENT	30.01.2025

Rev	Dm	Chkd	Amendments	Date

**FOR PART 8**

Drawing Sheet Size: A1

Client :	Dun Laoghaire Rathdown County Council
Project :	No. 09 George's Place, Dun Laoghaire
Title :	Site Plan
Drg No :	24139-STEM-XX-XX-DR-S-501
Scale :	AS SHOWN
Drn By :	BP
Date :	30.01.2025
Revision :	P02
Status :	S3
Aprvd By :	AS

**STEM**  
CONSULTING ENGINEERS

CIVIL & STRUCTURAL ENGINEERS

4-5 Burton Hall Road,  
Sandyford, Dublin,  
Ireland, D18 A094

Web: stemtech.ie  
E-mail: info@stemtech.ie